

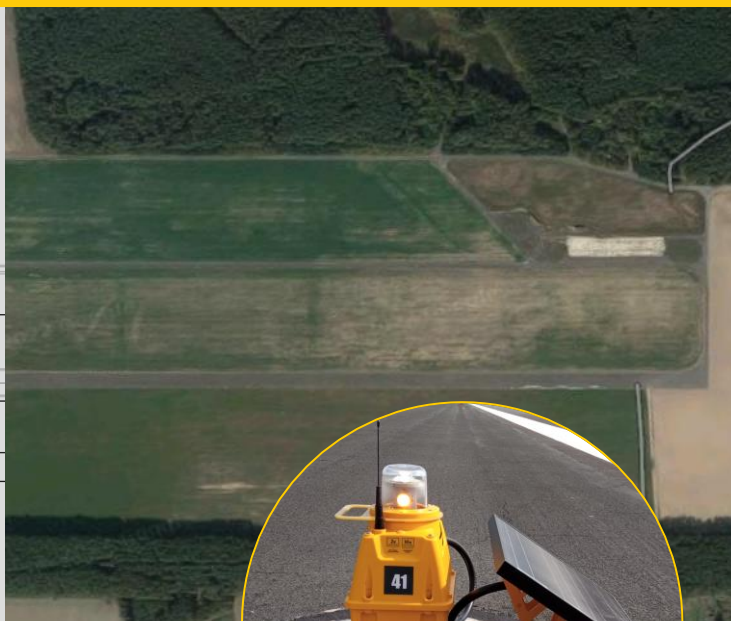


WORLD'S SAFEST RUNWAY LIGHTING


EXAMPLE OF SOLAR AGL DESIGN

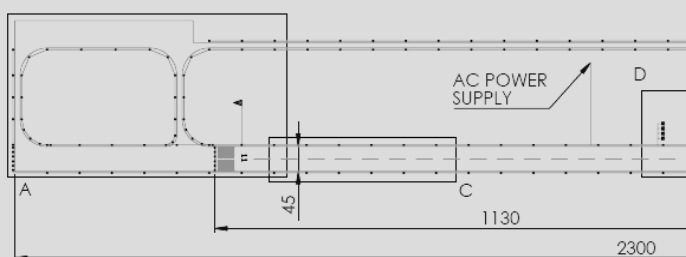



General Airfield Lighting Layout

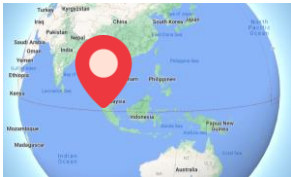



3 620 M RUNWAY
REGIONAL AIRPORT
MALAYSIA

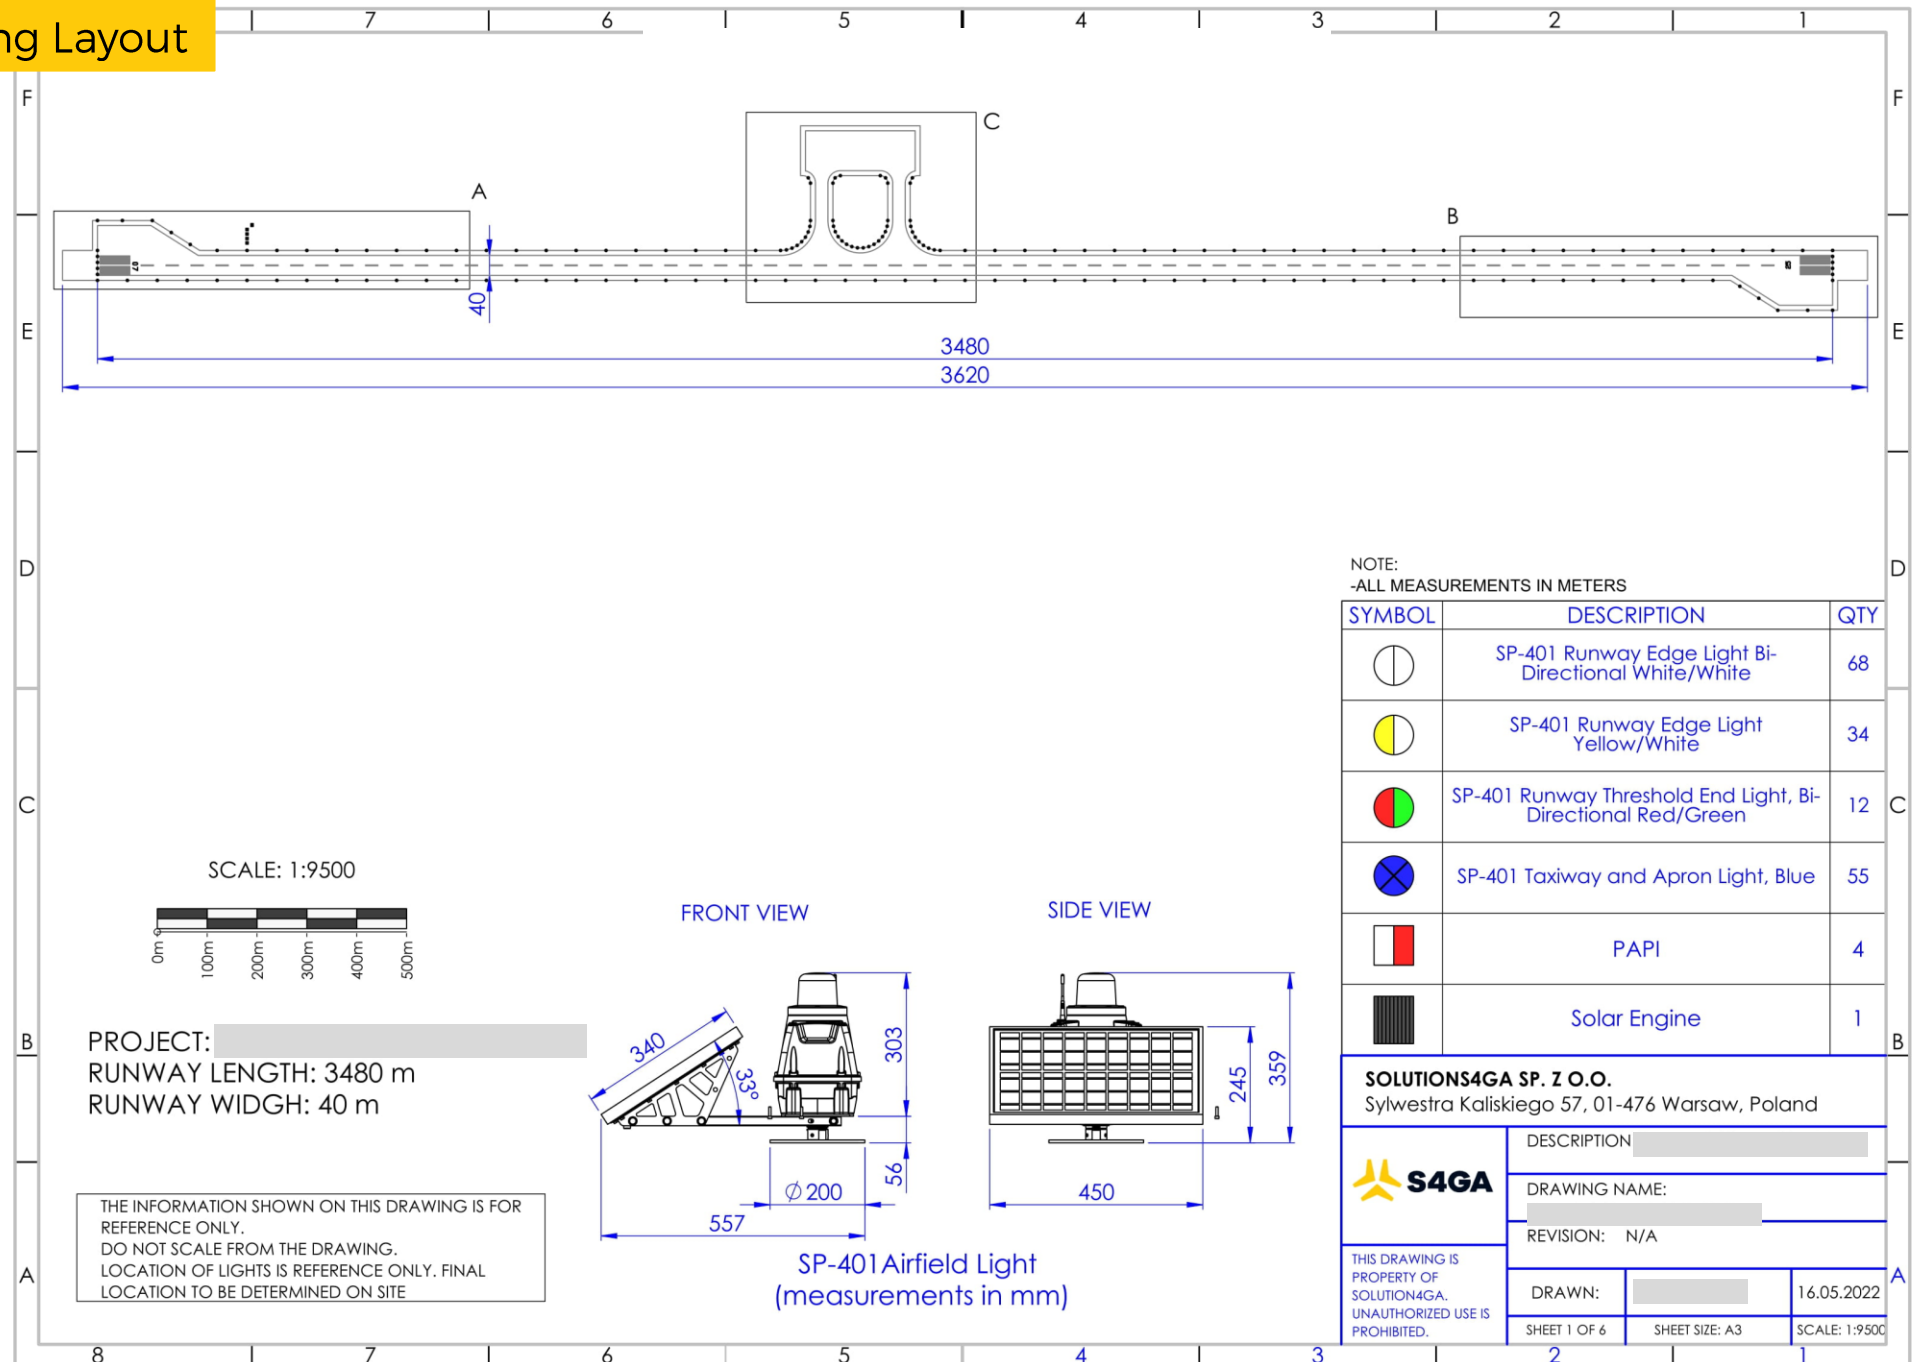



Detail A. Runway Approach 07

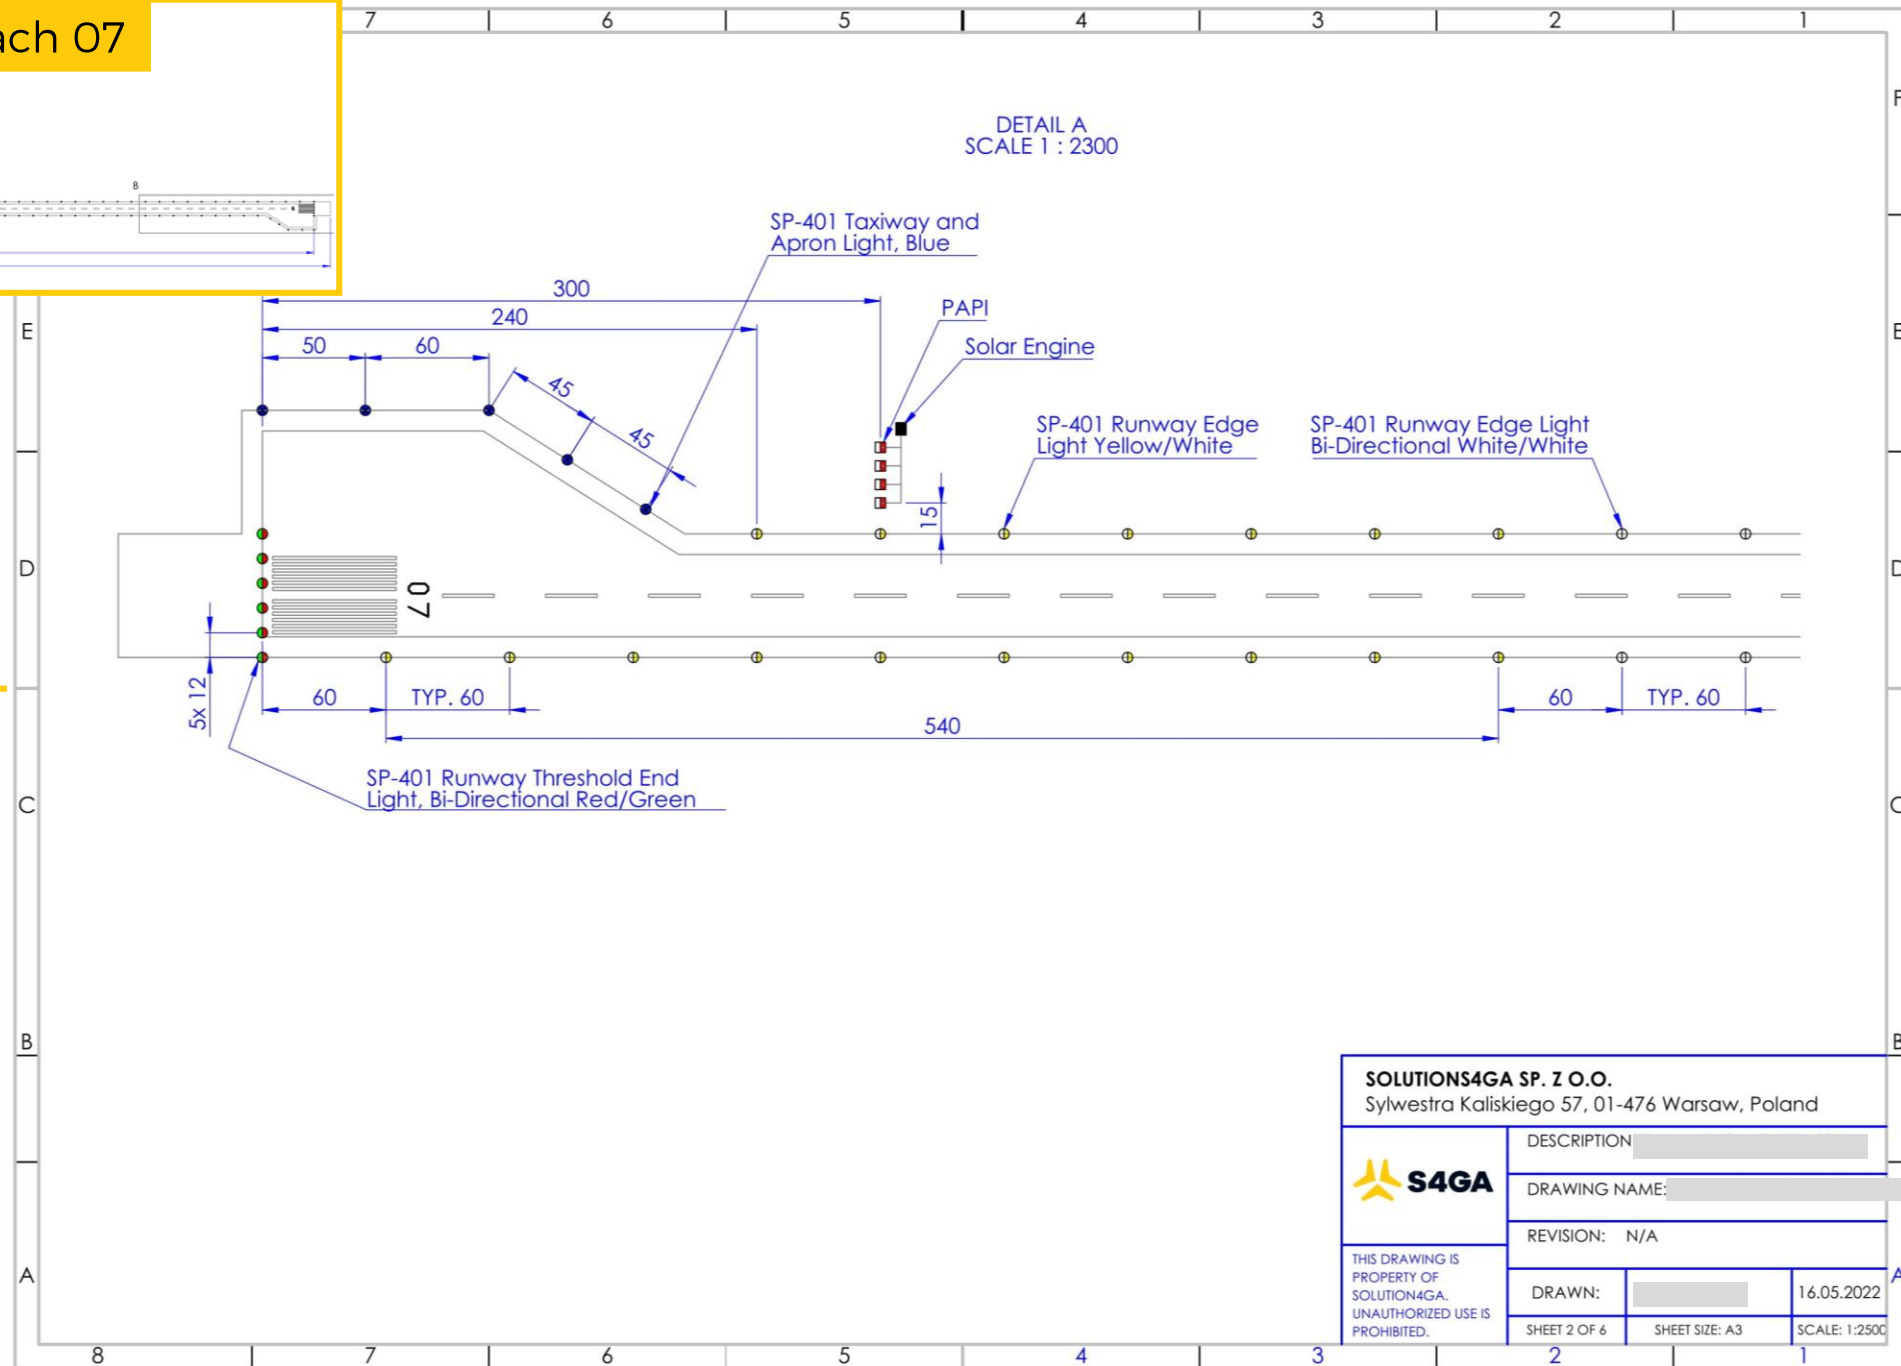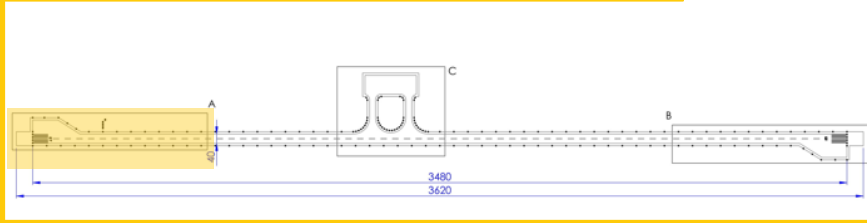

Detail B. Runway Approach 25

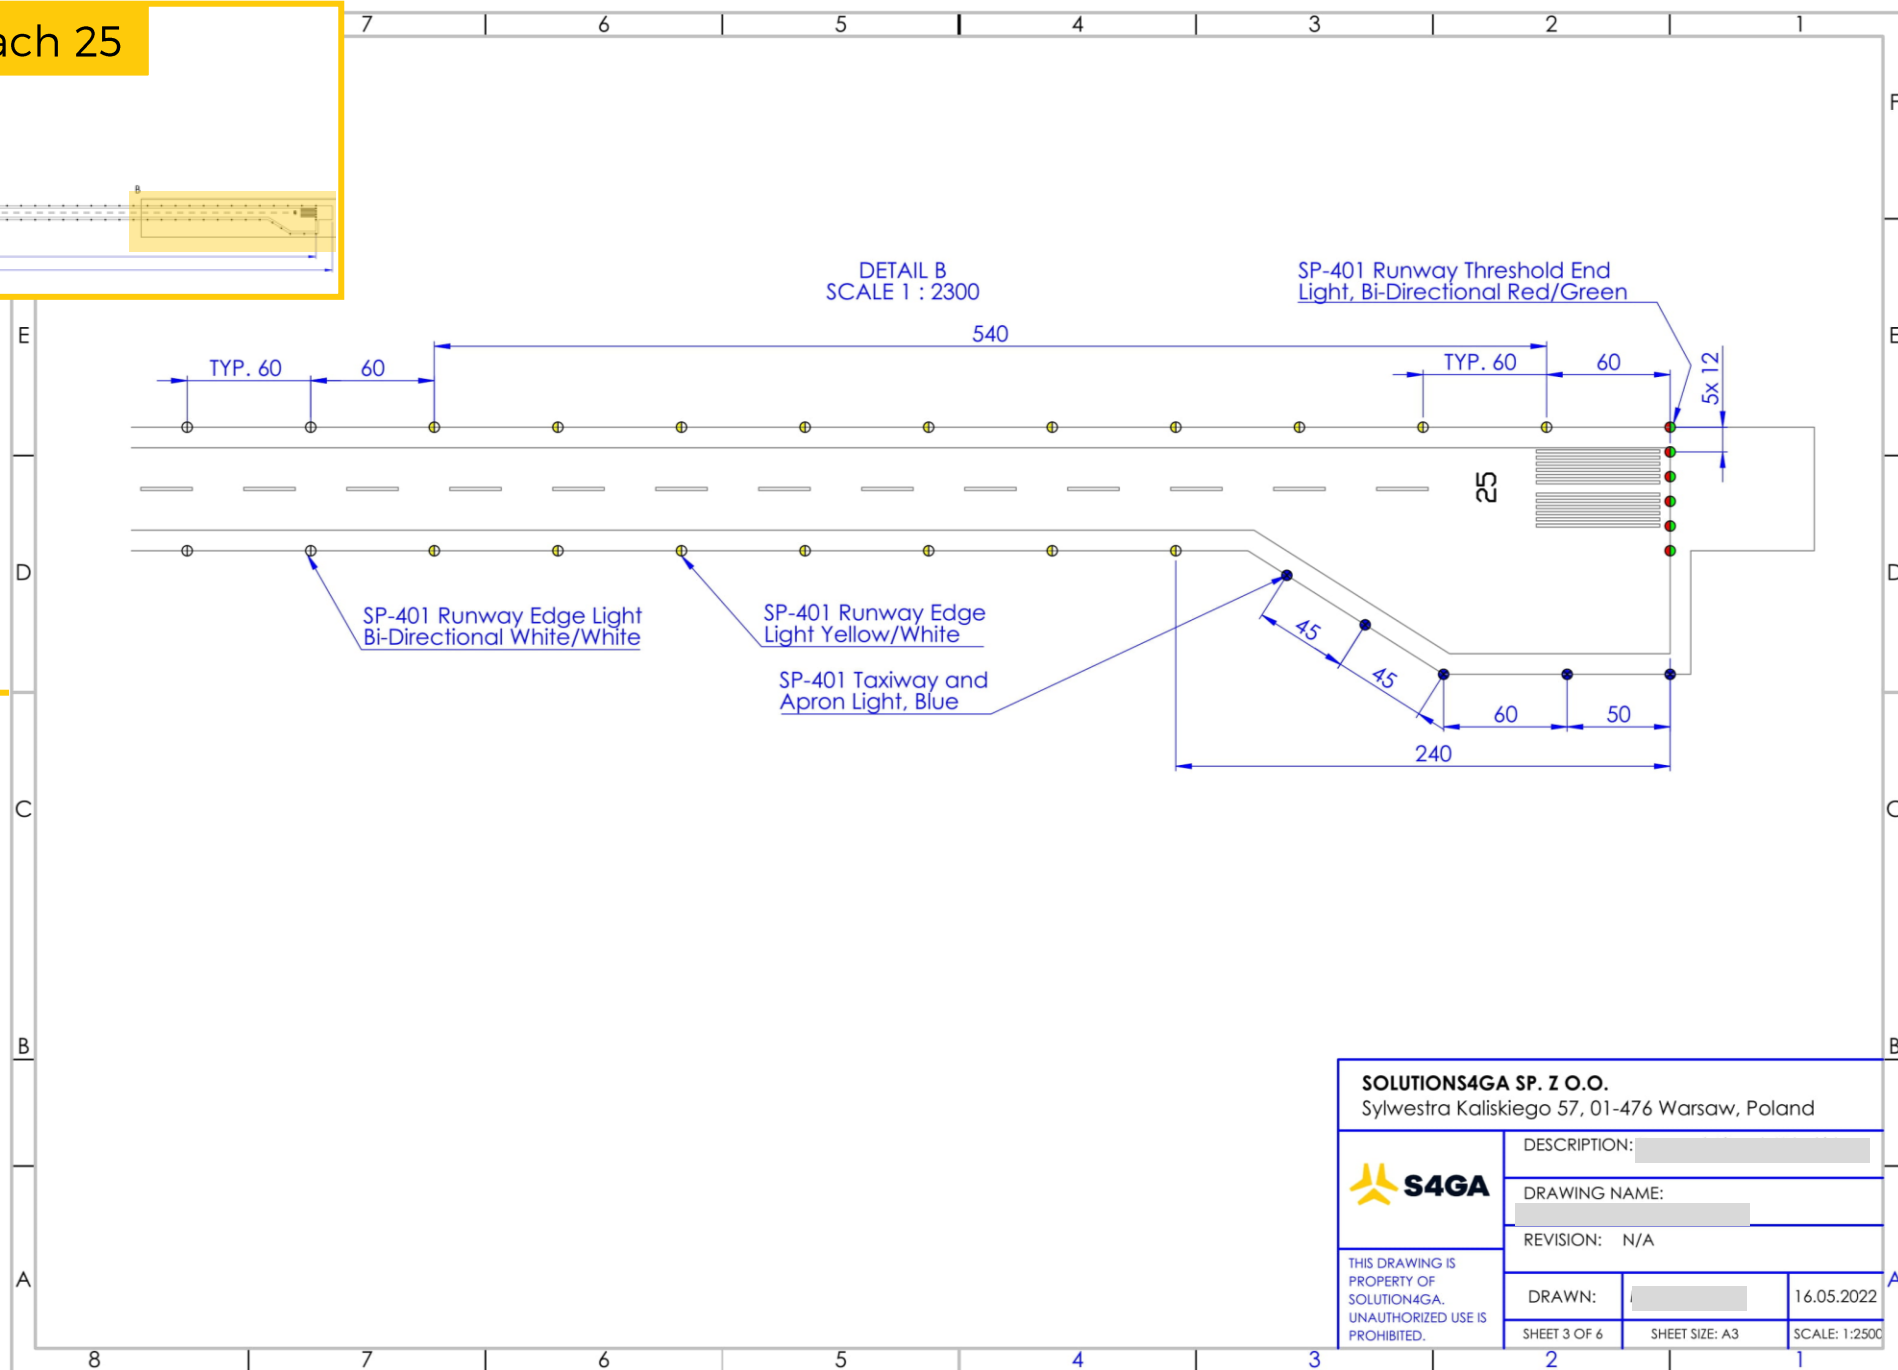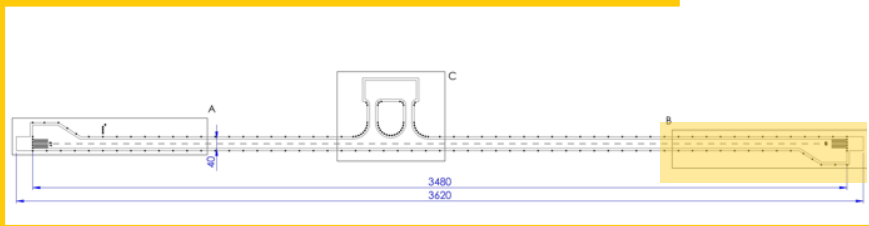


Detail C. Taxiways & Apron

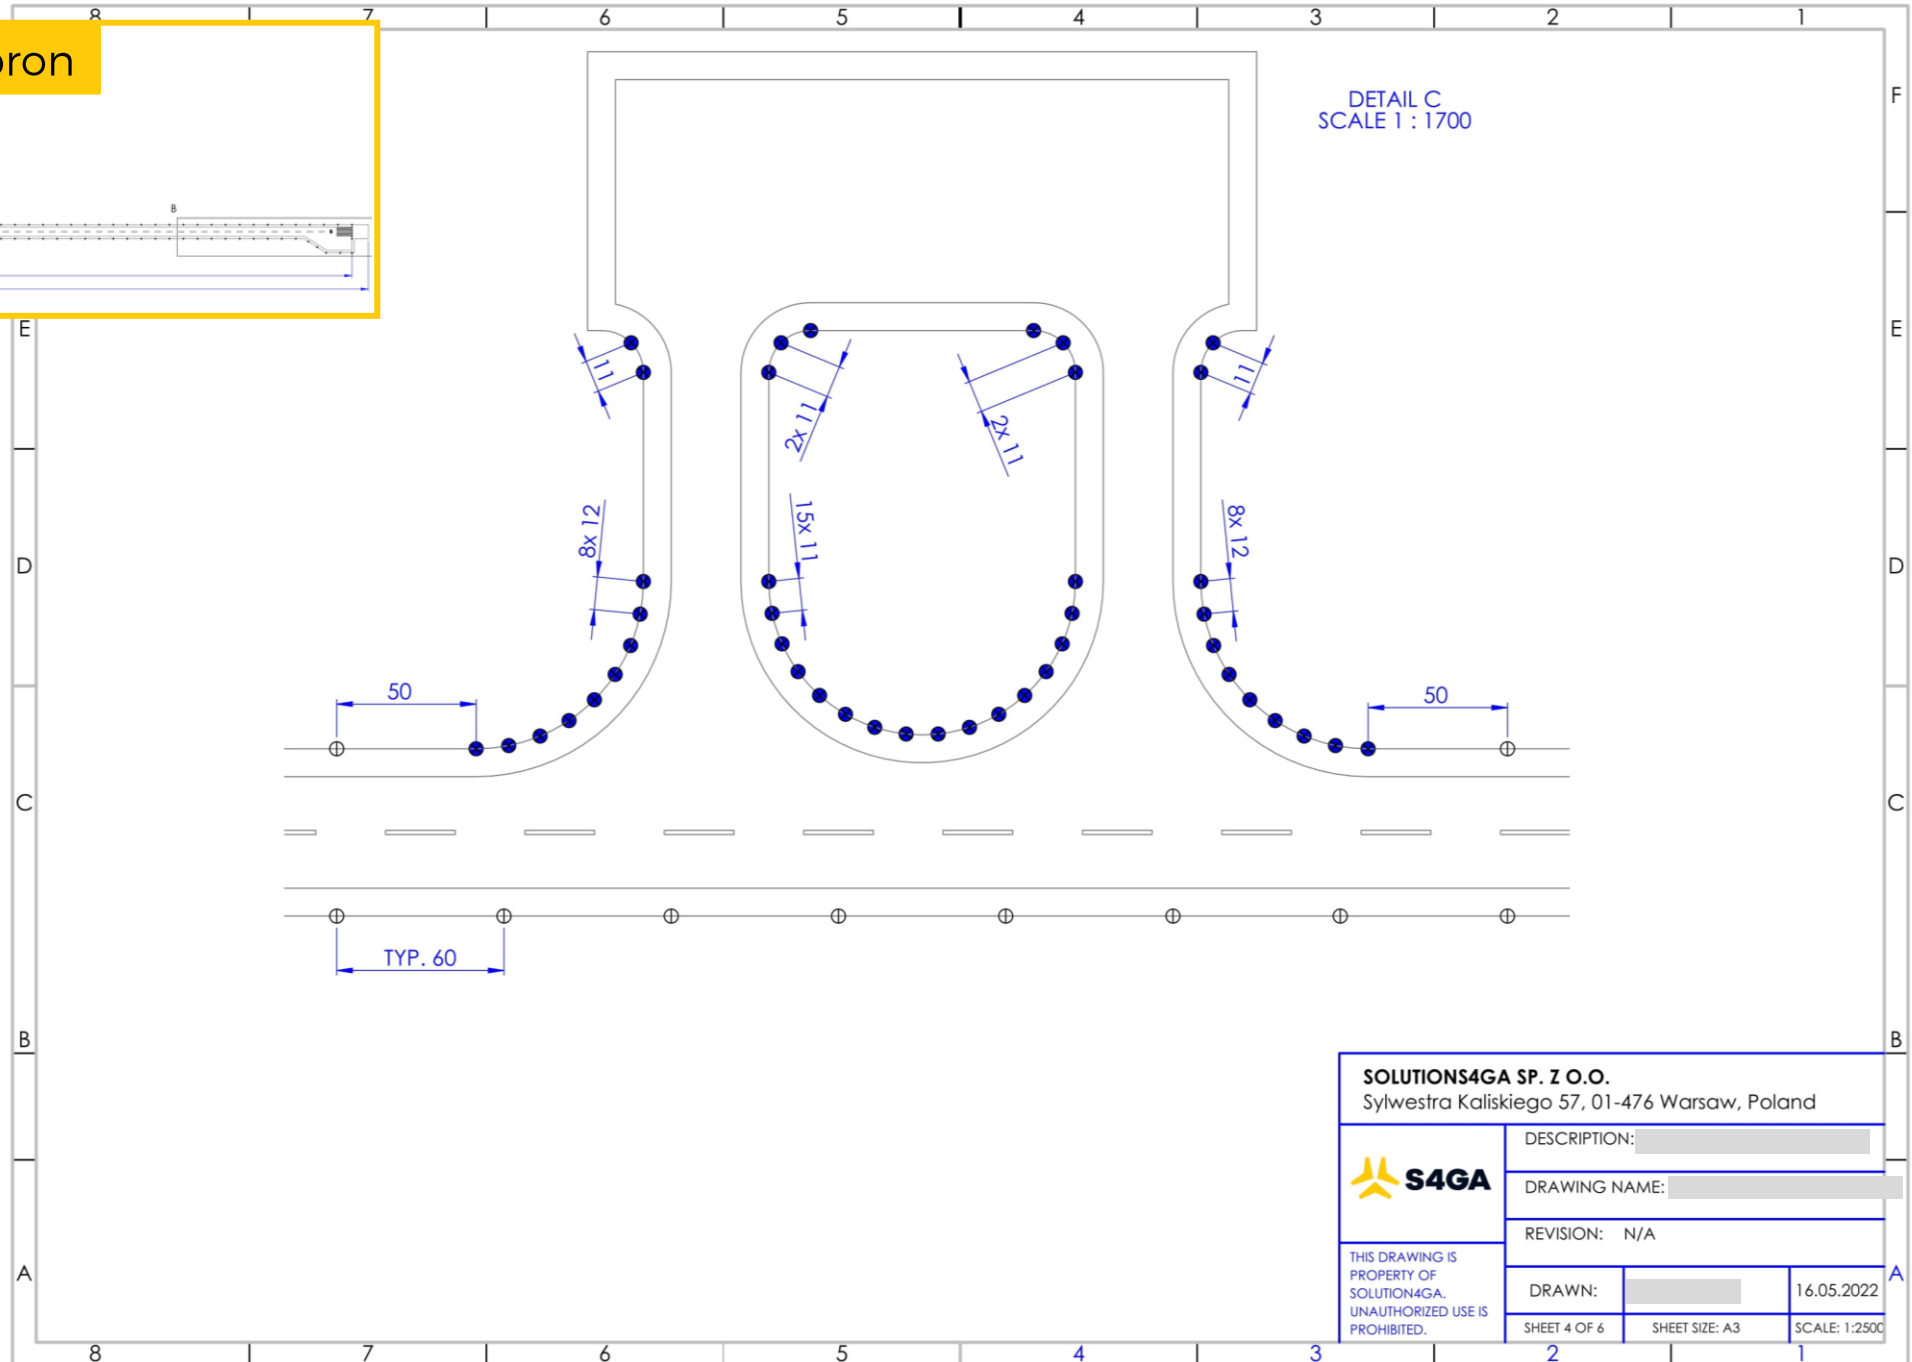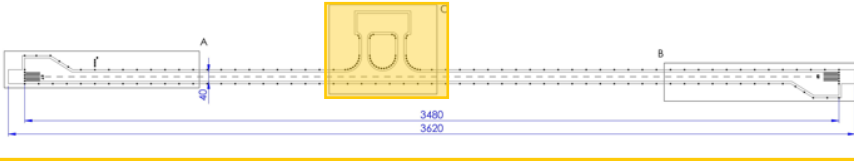


SOLUTIONS4GA SP. Z O.O. Sylwestra Kaliskiego 57, 01-476 Warsaw, Poland		
	DESCRIPTION: _____	
	DRAWING NAME: _____	
	REVISION: N/A	
	THIS DRAWING IS PROPERTY OF SOLUTION4GA. UNAUTHORIZED USE IS PROHIBITED.	
DRAWN:	_____	16.05.2022
SHEET 4 OF 6	SHEET SIZE: A3	SCALE: 1:2500

S4GA Equipment. SP-401 Solar Airfield Light

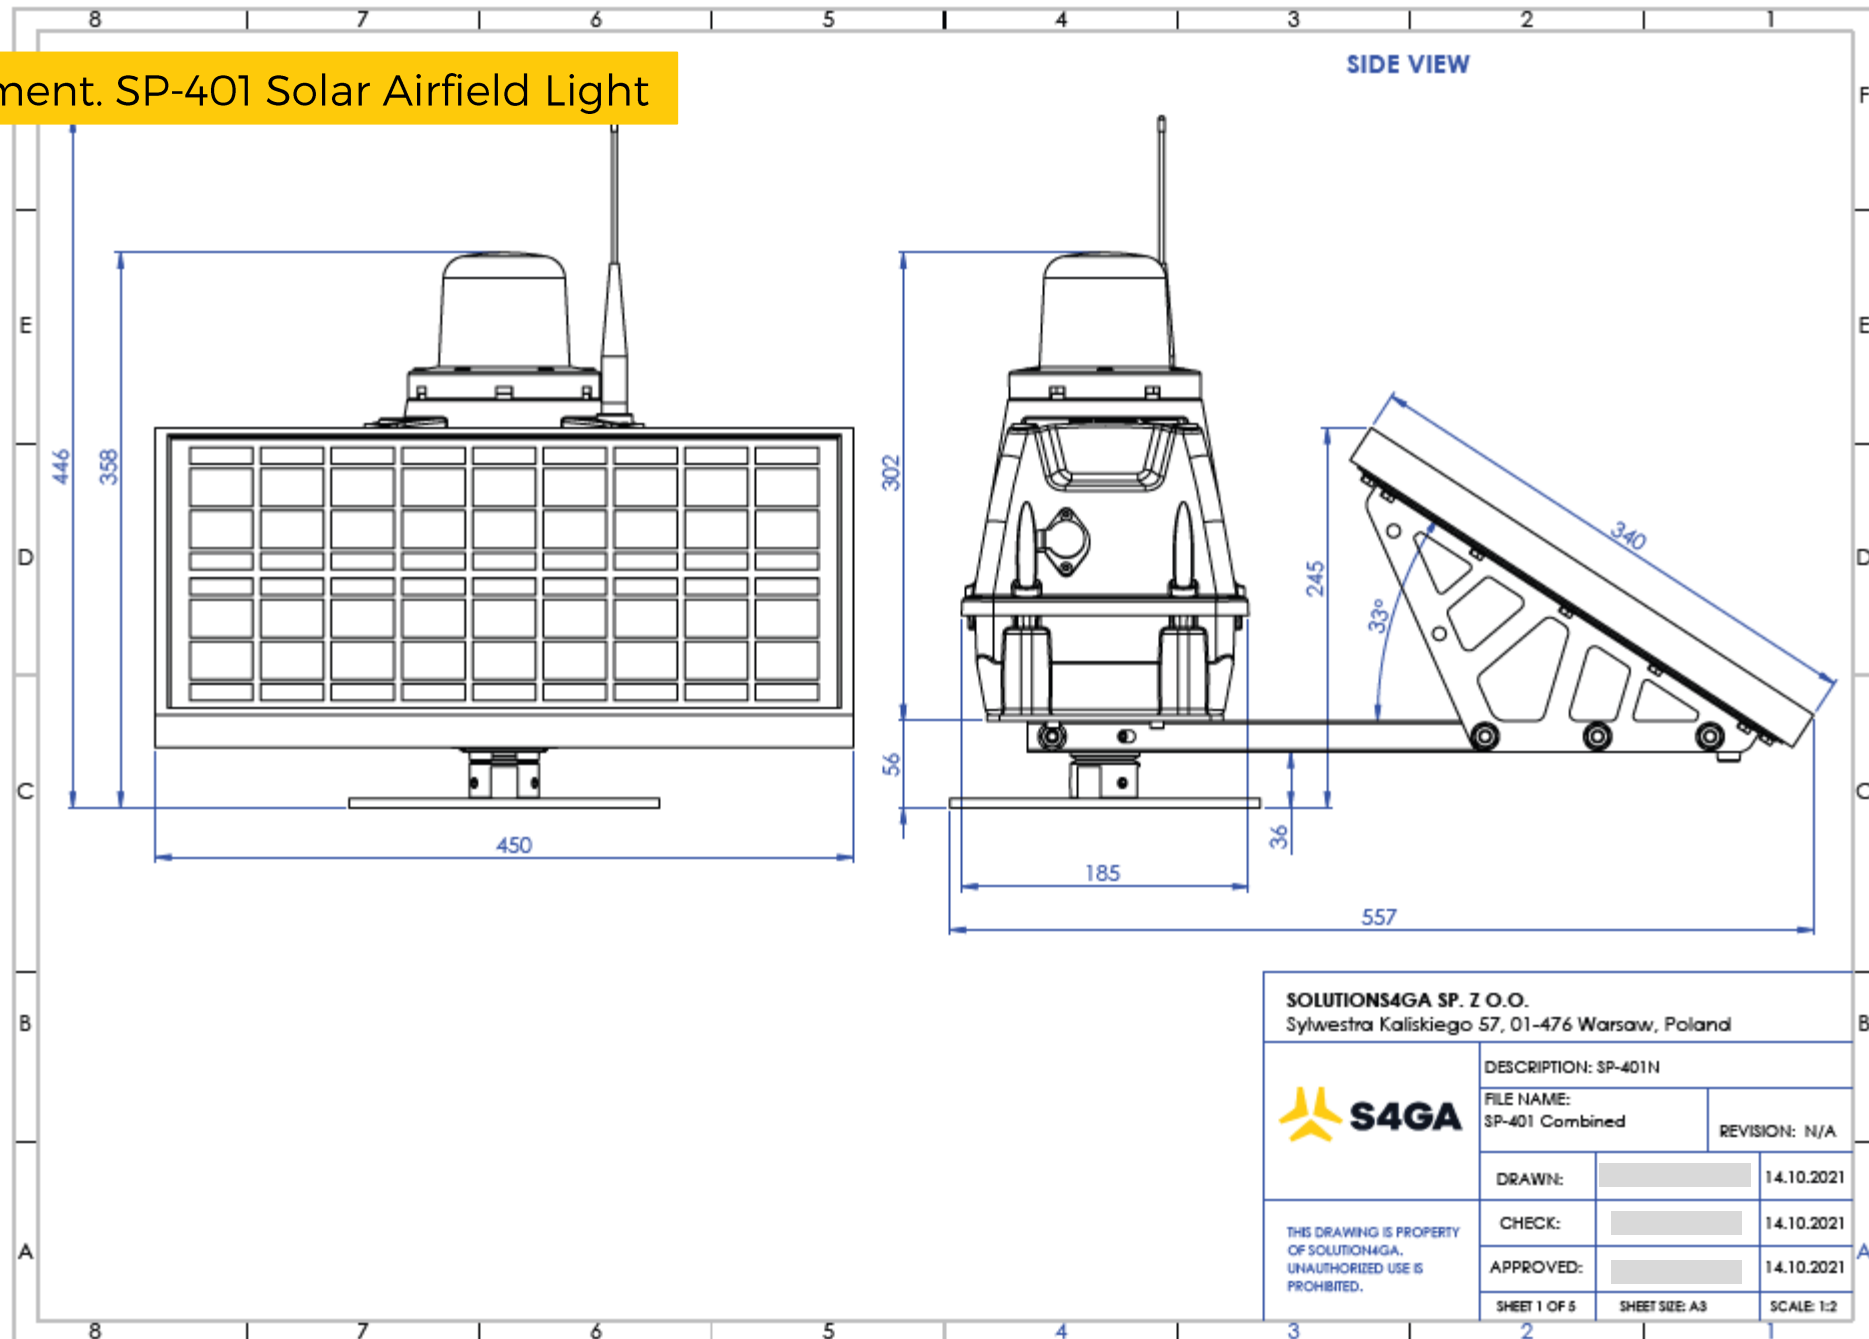


S4GA Equipment. LED PAPI

PAPI (measurements in mm)

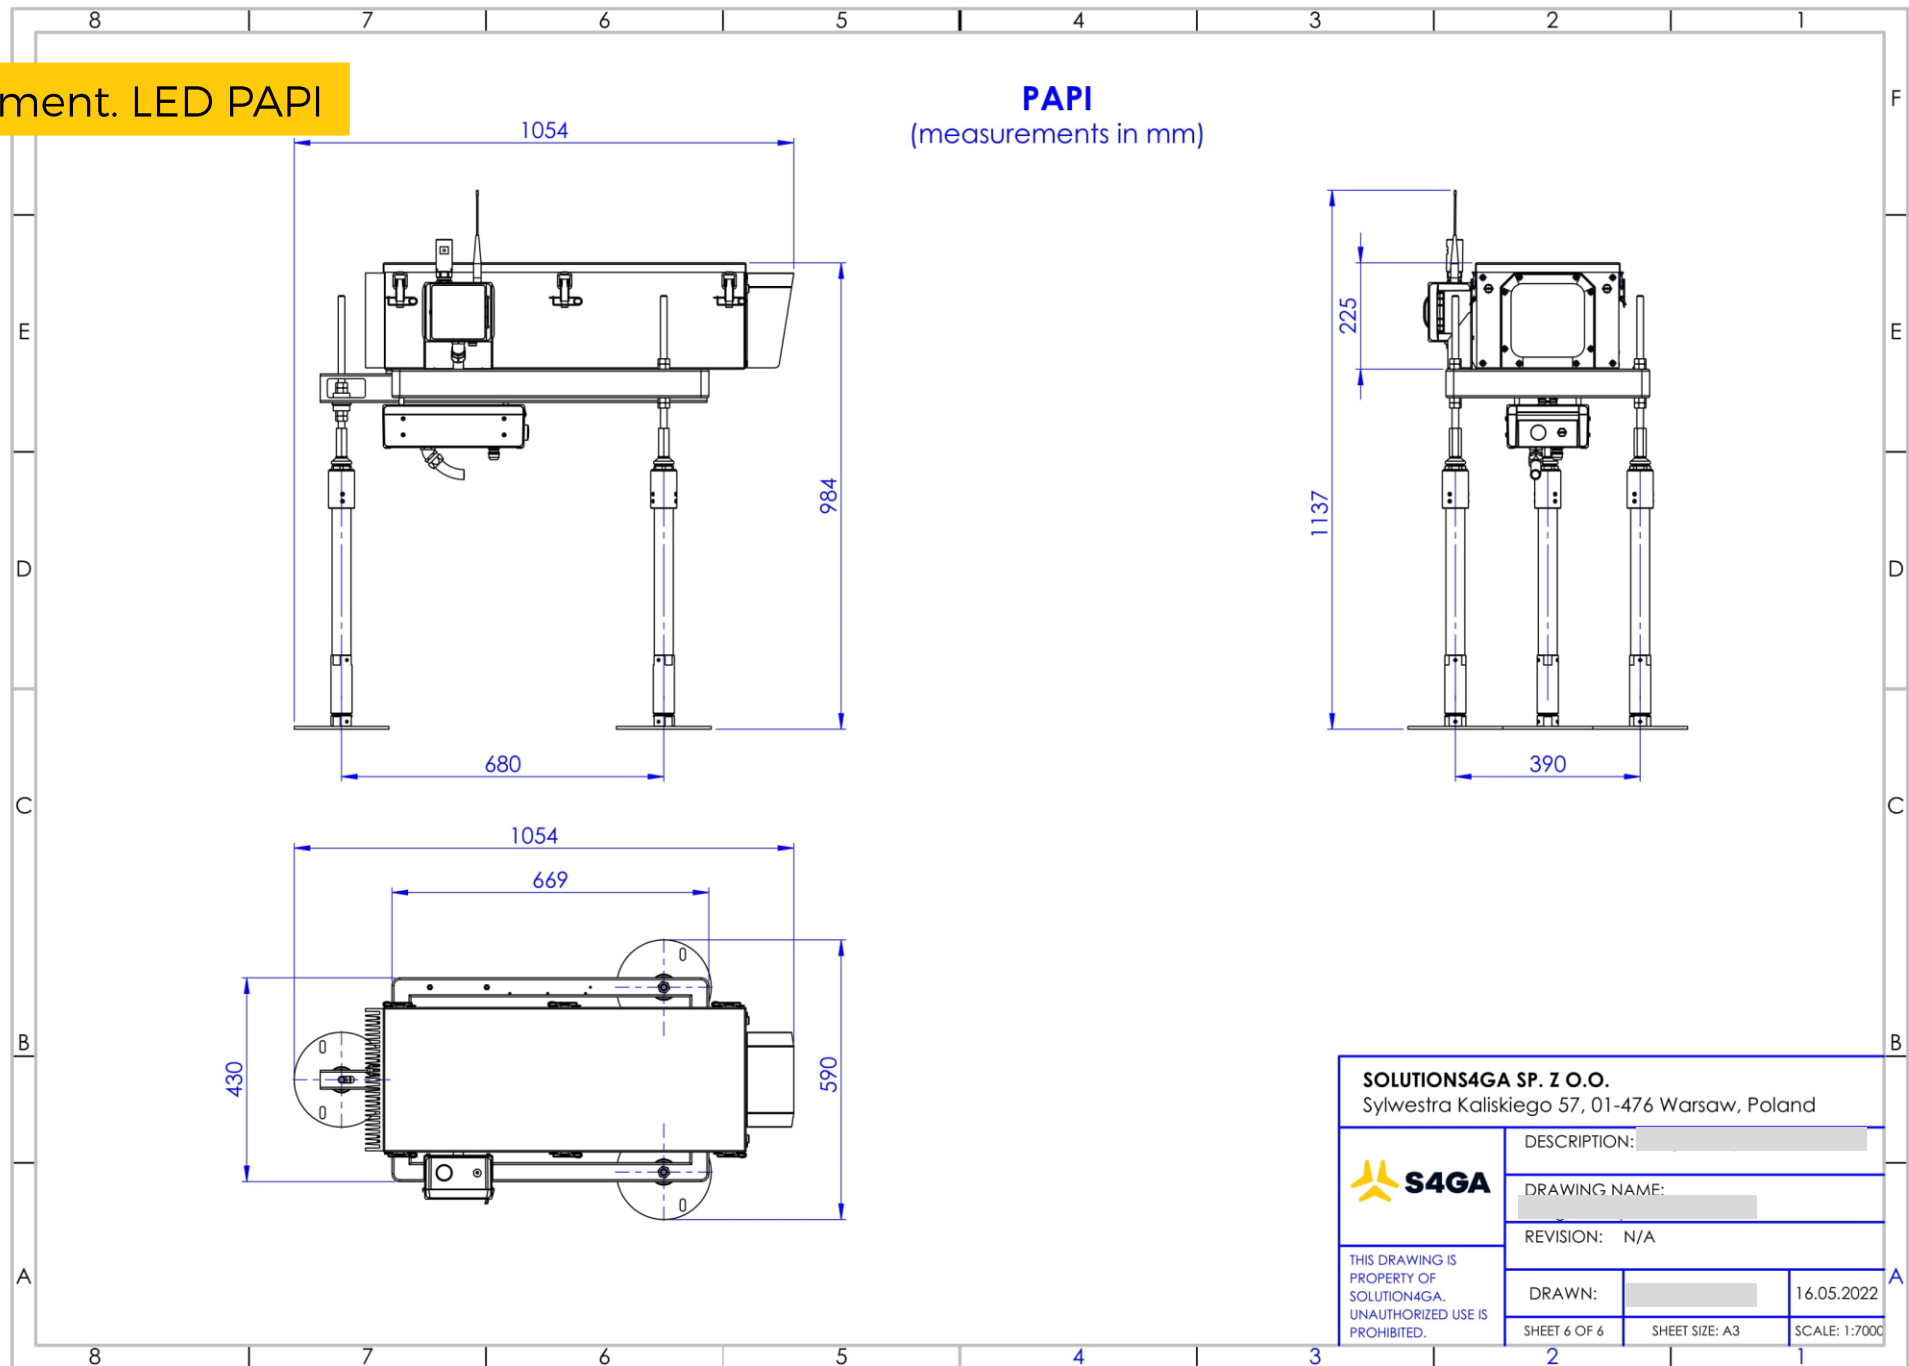

S4GA Equipment. SE-302 Solar Engine

Solar Engine
(measurements in mm)

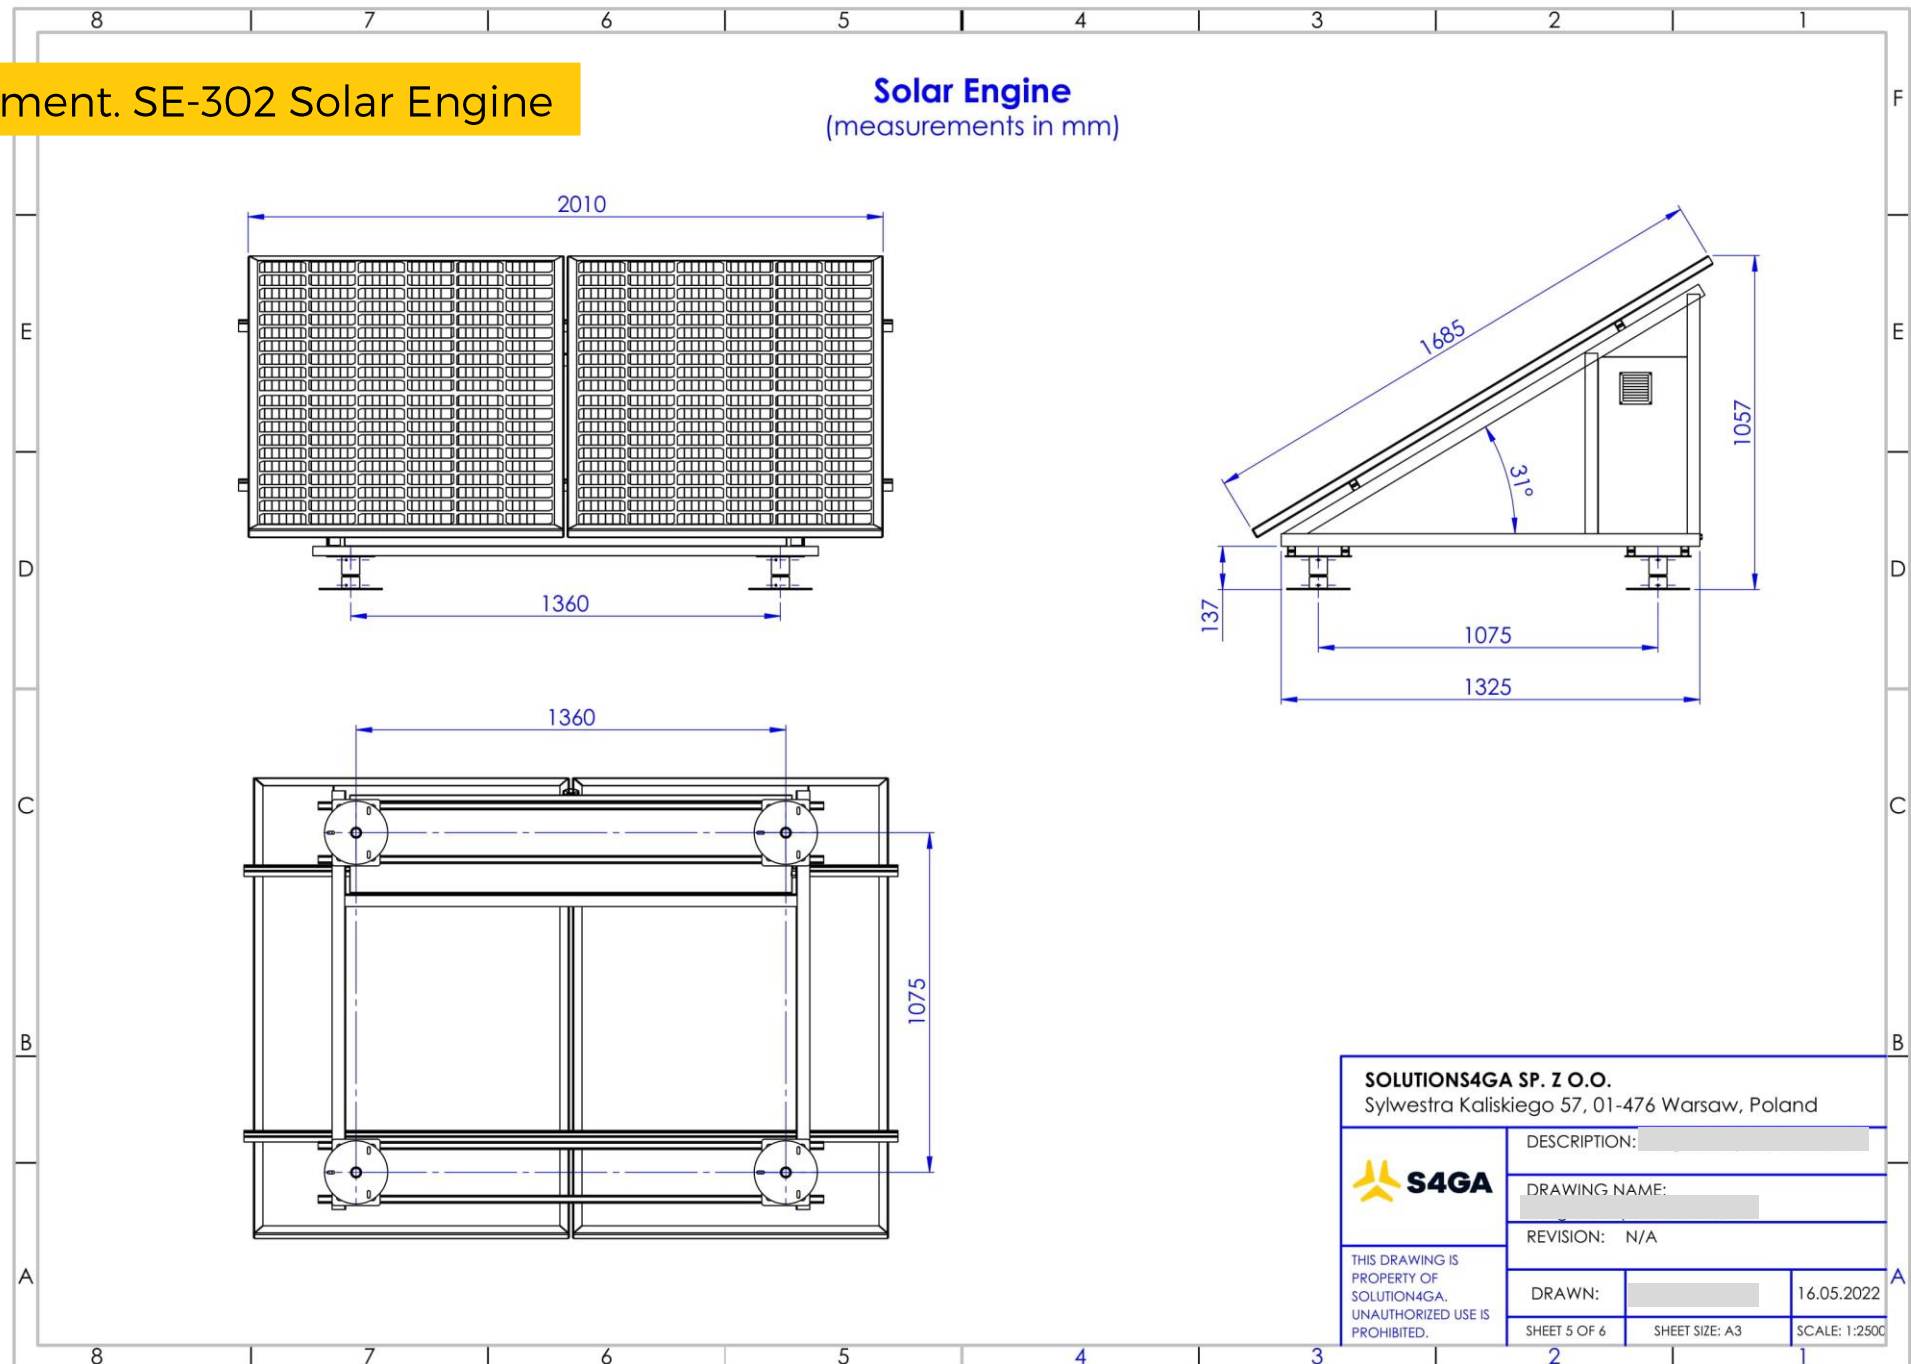

SOLUTIONS4GA SP. Z O.O.
Sylwestra Kaliskiego 57, 01-476 Warsaw, Poland



THIS DRAWING IS
PROPERTY OF
SOLUTIONS4GA.
UNAUTHORIZED USE IS
PROHIBITED.

DESCRIPTION:		
DRAWING NAME:		
REVISION: N/A		
DRAWN:	16.05.2022	
SHEET 5 OF 6	SHEET SIZE: A3	SCALE: 1:2500

ORDER

SOLAR AIRFIELD LIGHTING DESIGN
FOR YOUR AIRPORT

OFFICE@SOLUTIONS4GA.COM



Solutions4ga sp. z o. o.
01-476 Sylwestra Kaliskiego 57
Warsaw, Poland

WORLD'S SAFEST RUNWAY LIGHTING

www.solutions4ga.com
+48 22 307 10 01 | office@solutions4ga.com